
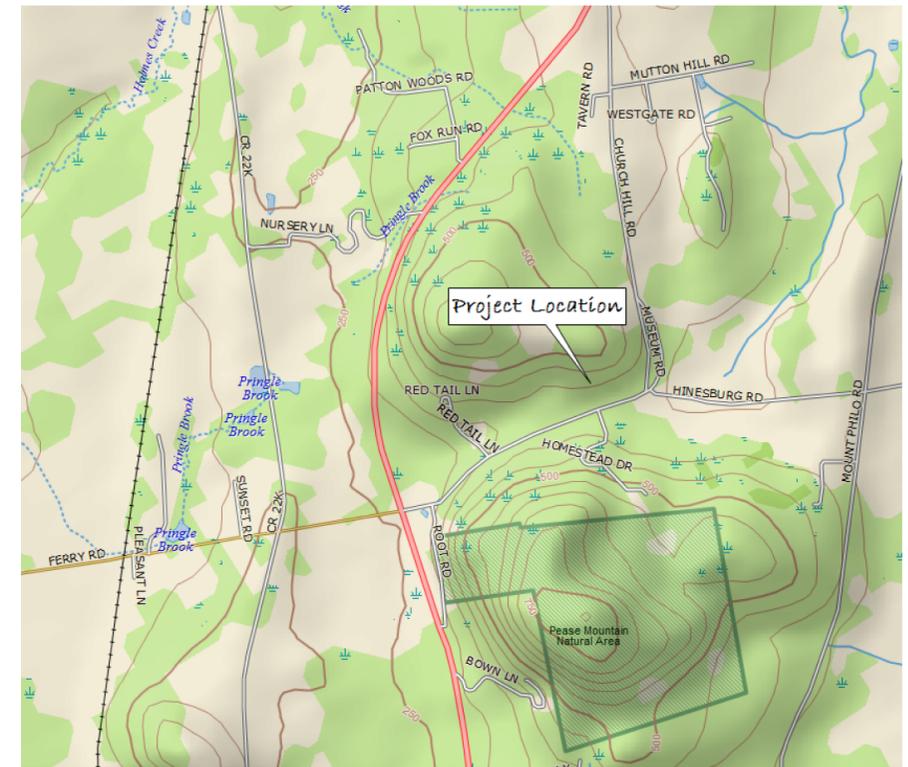


NOTES:

- PARCEL, 2' CONTOUR & SITE PLAN INFORMATION OBTAINED FROM VCGI & MARKERS LOCATED IN THE FIELD
- FIELD DATA COLLECTED WITH JAVAD TRIUMPH LS RTK RECEIVER
- THIS PLAN IS INTENDED FOR SEPTIC PERMITTING ONLY AND NO OTHER USE IS PERMITTED
- PRIOR TO ANY CONSTRUCTION ON THE PARCEL, A SITE VISIT SHALL TAKE PLACE WITH THE OWNER, CONTRACTOR & DESIGNER TO DISCUSS & VERIFY SYSTEM & WELL LOCATIONS
- PROPOSED DRIVEWAY LOCATION PROVIDED BY OWNER
- THE DESIGNER HAS DETERMINED A LOCATION FOR WASTEWATER DISPOSAL SYSTEMS ON THE PROPERTY BASED ON A SITE EVALUATION & SOIL TEST PITS.
- THE OWNER OF THE PARCELS IS RESPONSIBLE FOR PROPER OPERATION & MAINTENANCE OF THE PROPOSED SYSTEM TO PROTECT PUBLIC HEALTH & GROUNDWATER
- THE SEPTIC TANKS SHALL BE CHECKED FOR SOLIDS ON A YEARLY BASIS & PUMPED AS NEEDED. THE DISTRIBUTION BOX SHALL ALSO BE CHECKED AT THIS TIME & CLEANED IF NECESSARY
- THE LIFE OF THE SYSTEM CANNOT BE ESTIMATED DUE TO CONDITIONS BEYOND THE CONTROL OF THE DESIGNER SUCH AS EXCESS GROUNDWATER, RAINWATER, & THE INTRODUCTION OF FOREIGN MATERIAL INTO THE SYSTEM
- WATER SAVING DEVICES AND WATER CONSERVATION IS RECOMMENDED
- DUE TO INSTANCES BEYOND THE CONTROL OF THE DESIGNER, THE DESIGNER ASSUMES NO RESPONSIBILITY FOR THE CONTINUED FUNCTIONING AND PROPER USE & MAINTENANCE OF THE SYSTEM
- GARBAGE DISPOSAL ARE NOT RECOMMENDED. IF THEY ARE USED, THE SEPTIC TANK SHALL BE DOUBLED IN SIZE.
- PRIOR TO CONSTRUCTION THE OWNERS SHALL REVIEW THE PLANS & CONTACT THE DESIGNER WITH ANY QUESTIONS REGARDING THE PLANS. MODIFICATIONS TO THE DESIGN OR CONSTRUCTION PROCEDURES MAY LEAD TO SYSTEM FAILURE WITH NO RESPONSIBILITY OF THE DESIGNER
- THIS PLAN IS INTENDED TO MEET THE CURRENT STATE OF VERMONT WASTEWATER RULES.
- THIS PLAN IS INTENDED FOR WASTEWATER PERMITTING ONLY, NOT VALID FOR ANY OTHER USE.

BASIS OF DESIGN
Proposed 1-2-BR Residence

2- BR's @ 140 GPD = 280 GPD
Use Loading Rate - 1 gal/sq ft.
Disposal Area: 280 gal/1 gal/sq ft.
Required Area = 280 sq. ft.
Area Provided = 288 sq. ft.

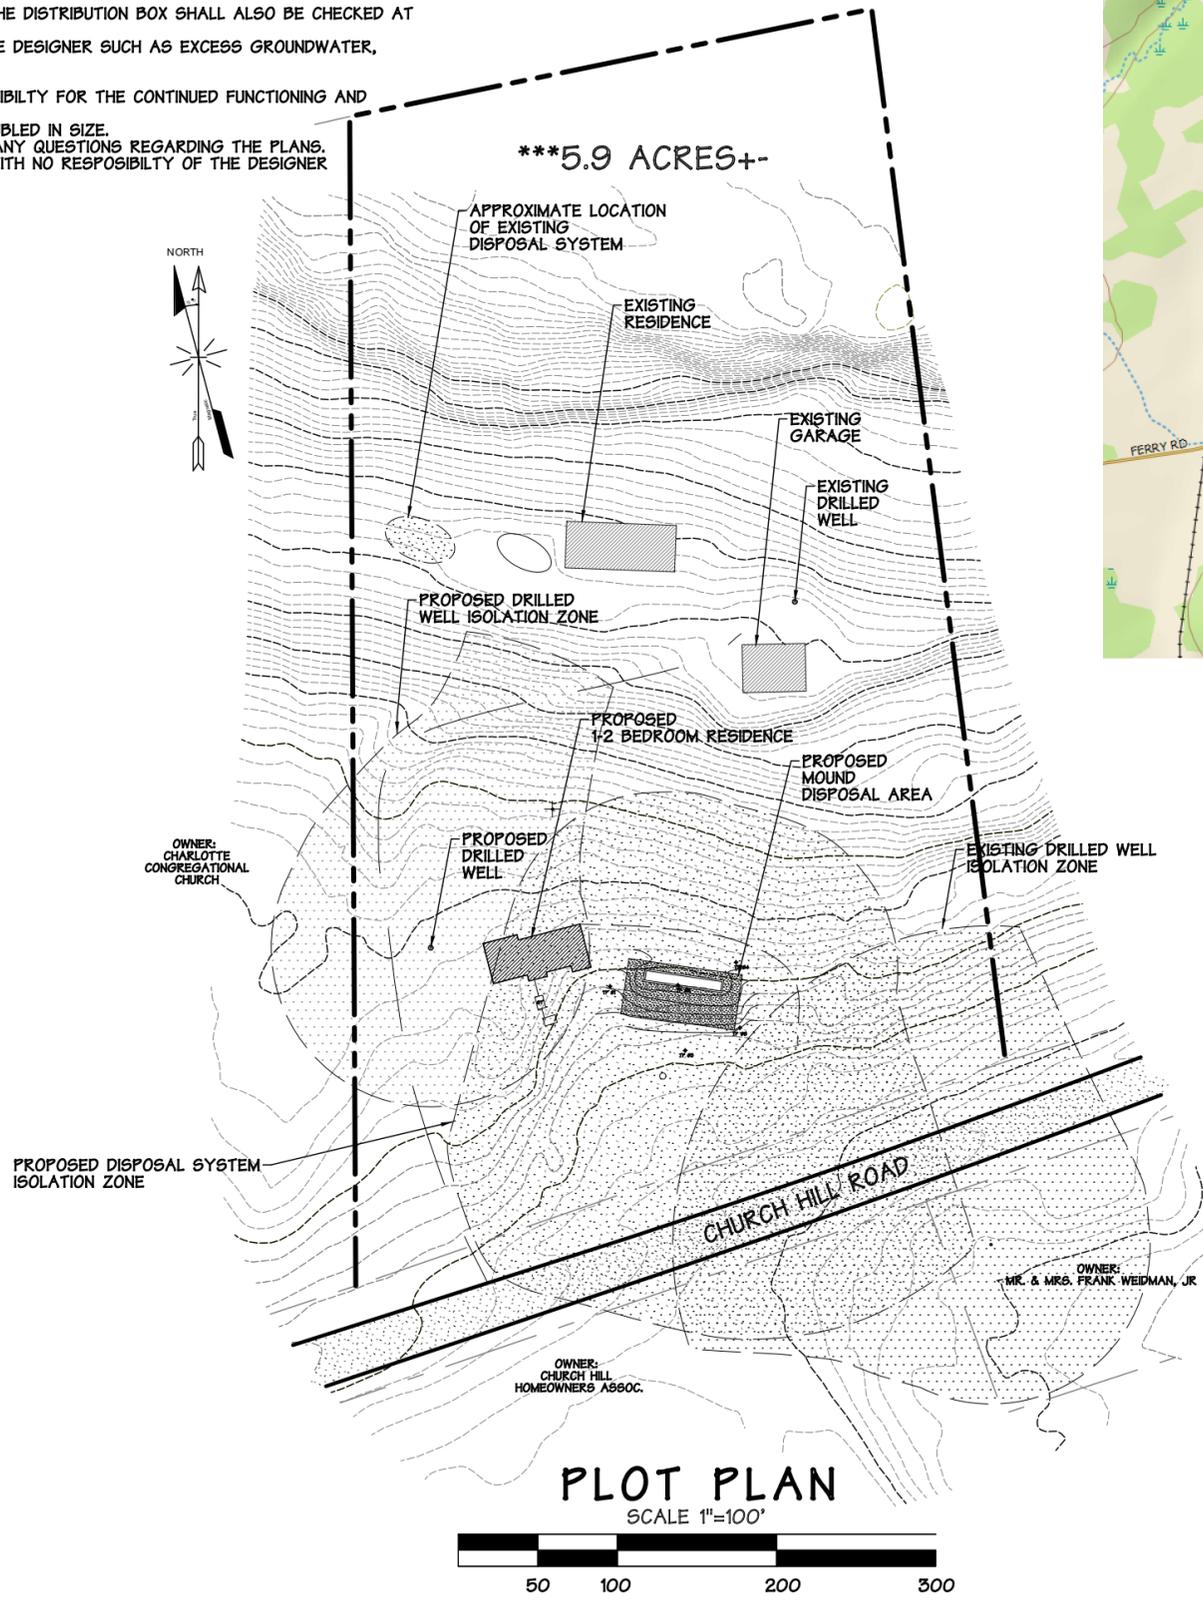

No.	DATE	DESCRIPTION	BY

STATE OF VERMONT
SPENCER K. HARRIS
NO. 310-B
LICENSED DESIGNER

COYLE ACCESSORY STRUCTURE
SEPTIC DESIGN
CHARLOTTE, VERMONT

VERMONT CONTOURS INC.

SEPTIC SYSTEM DESIGNS
TOPOGRAPHIC SITE PLANS & MAPPING
G.P.S. MAPPING
P.O. BOX 384
BRISTOL, VERMONT 05443
453-2351

Drawn: SKH
Date: 11/11/15
Scale: AS SHOWN
Project: COYLE
Sheet: 1 OF 3