




LOT 2
10.10 ACRES

7.39 ACRES
BOUNDARY ADJUSTMENT

LOT 3
7.38 ACRES

LOT 1
5.56 ACRES

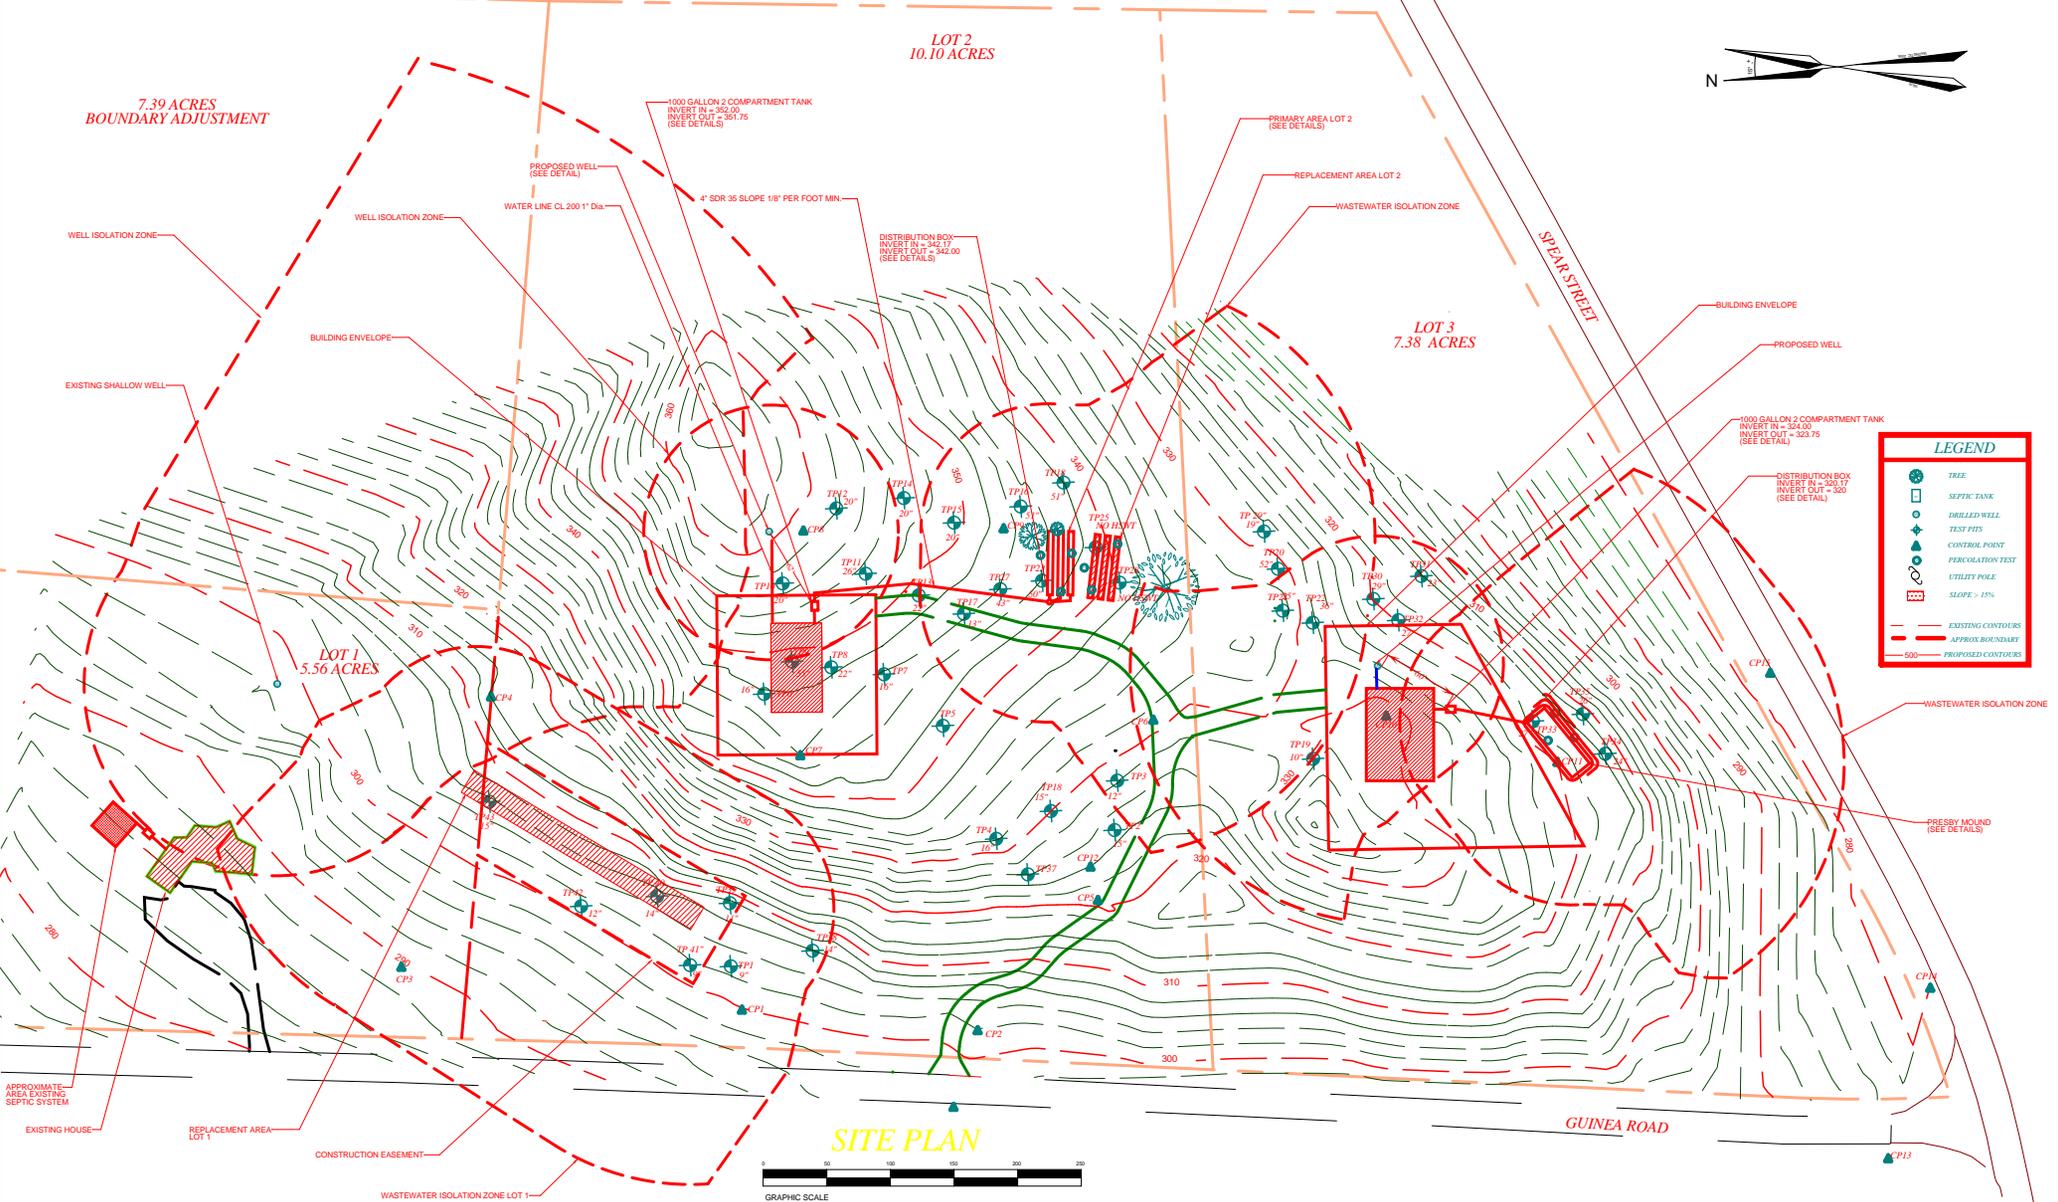

LEGEND	
	TREE
	SEPTIC TANK
	DRILLED WELL
	TEST PITS
	CONTROL POINT
	PERCOLATION TEST
	UTILITY POLE
	SLOPE > 15%
	EXISTING CONTOURS
	APPROX BOUNDARY
	PROPOSED CONTOURS

SITE PLAN



SCALE 1" = 50'

3/31/14	ADDED WASTEWATER SHIELD REPLACEMENT AREA LOT 1	JK

THIS DESIGN IS PROPOSED TO SATISFY CRITERIA AND MEET THE INTENT OF THE VERMONT ENVIRONMENTAL PROTECTION RULES CHAPTER 1 WASTEWATER SYSTEM AND POTABLE WATER SUPPLY RULES EFFECTIVE SEPTEMBER 26, 2007.



WATER/WASTEWATER PLAN

DIKE PROPERTY
GUINEA ROAD
CHARLOTTE, VERMONT



WATER & WASTEWATER DESIGNS
TOPOGRAPHIC SITE PLANS & MAPPING
STATE & LOCAL PERMITTING
981 BIG HOLLOW ROAD
STARKSBORO, VERMONT 05487
453-5071

	JK
	JK
	JK
	JK
	JK