


NOTE: THE PROPOSED REPLACEMENT MOUND SYSTEM IS NOT LOCATED WITHIN ANY ON OR OFF-SITE WELL ISOLATION ZONE.

THERE ARE NO WASTEWATER DISPOSAL SYSTEMS, ON-SITE OR OFF-SITE, WITHIN THIS WELL ISOLATION ZONE.

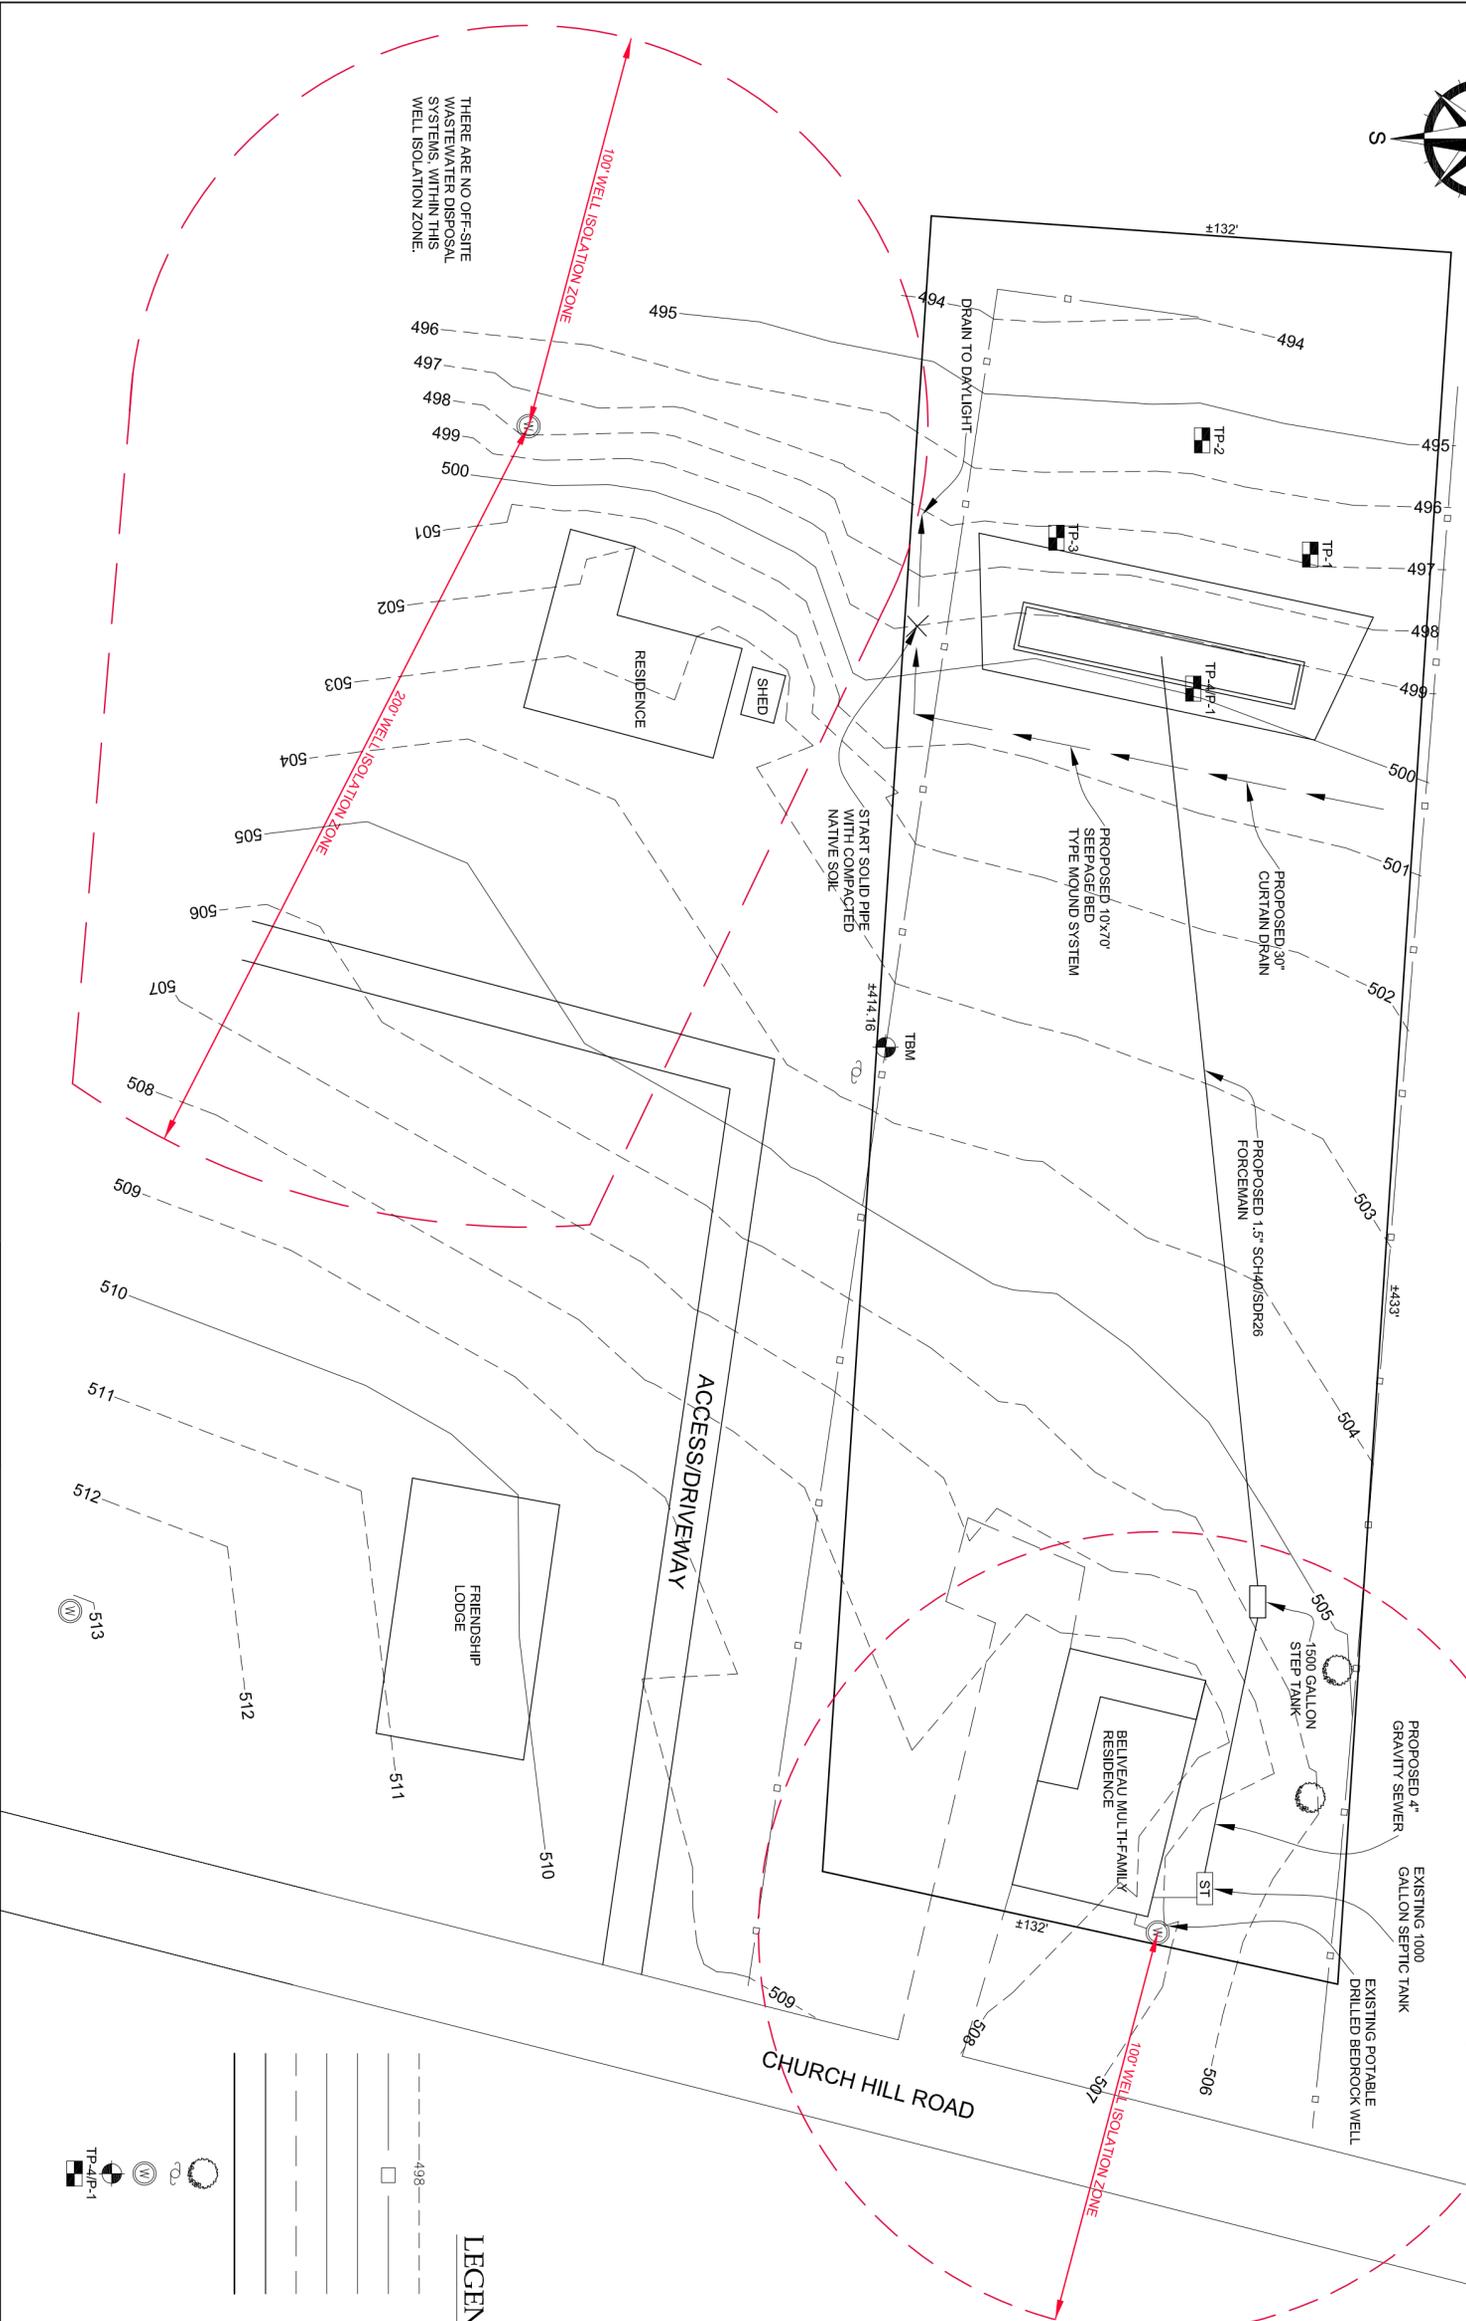


THERE ARE NO OFF-SITE WASTEWATER DISPOSAL SYSTEMS, WITHIN THIS WELL ISOLATION ZONE.

1"=30'

"I hereby certify that in the exercise of my reasonable professional judgment the design-related information submitted with this application is true and correct, and that the design included in this application for a permit complies with the Vermont Wastewater System and Potable Water Supply Rules and the Vermont Water Supply Rules."

Stephen Revell, CPG
Licensed Class B Designer #178

Date _____

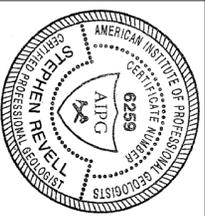

LEGEND

	EXISTING GROUND CONTOUR
	EXISTING FENCE LINE
	EXISTING SANITARY SEWER
	EDGE OF PAVEMENT
	EDGE OF GRAVEL DRIVE
	PROPOSED SANITARY LINE
	EXISTING PROPERTY LINE
	DECIDUOUS TREE
	UTILITY POLE
	WELL - DRILLED
	TEMPORARY BENCHMARK
	TEST PIT/ PERCOLATION TEST
	TP-4/P-1

Beliveau Property
1485 Church Hill Road
Charlotte, Vermont

Site Plan With Water & Wastewater Systems

LAG PROJECT # 08092
DATE November 11, 2008
SURVEYORS EET/TAM
DRAWN TAM

1 OF 2